

	UMINAIRE SCHEDULE					
FIXTURE TYPE	DESCRIPTION	MANUFACTURER	MODEL #	VOLTS	MOUNTING	LAMP
G	SCONCE W/LED LAMP	HINKLEY	1470BK	120V 1P 2W	SURFACE	(1) 60W EQ. LED 760LM 30M
L	EXTERIOR LED	LSI	XWM-FT-LED-8L-30-UE-BRZ	120V 1P 2W	SURFACE	62W LED 7345L 30K
U	LED POLE MOUNTED PARKING LOT FIXTURE W/INTERNAL LOUVER	LSI	MRM-LED-7L-SIL-FT-UNV-30-70CRI	120V 1P 2W	POLE W/OAH 15'-0"	53W LED 4334L 30K

D

LIGHT FIXTURE SCHEDULE GENERAL NOTES: 1. FINAL FIXTURE HOUSING COLORS AND FINISH SELECTIONS BY ARCHITECT. SOME MAY BE DETERMINED DURING SUBMITTAL PROCESS.

 
LIGHT FIXTURE SCHEDULE KEYED NOTES:

 \bigcap

1. PROVIDE LAMP QUANTITY AS STATED, MODEL: GE 60W LED EQUIVALENT WARM WHITE A19 FROSTED LAMP (OR EQUIVALENT).

2. FIXTURE SHALL BE MOUNTED 20'-0" AFF TO TOP OF FIXTURE. 3. COORDINATE MOUNTING HEIGHT WITH ARCHITECT.

4. FIXTURE SHALL HAVE AN OVERALL MOUNTING HEIGHT INCLUDUNG THE POLE BASE OF 15'-0" TO THE TOP OF THE FIXTURE




KZZ 2MI

TRUE NORTH PLAN NORTH

GENERAL NOTES:

- 1. CONNECT ALL EXTERIOR LIGHTING WITH #10 IN 1" PVC BURIED A MINIMUM OF 24" BELOW GRADE UNLESS NOTED OTHERWISE.
- 2. ELECTRICAL CONTRACTOR SHALL COORDINATE EXACT REQUIREMENTS WITH UTILITY TO PROVIDE ALL PARTS, TRENCHING, AND PAY ALL FEES NECESSARY TO BRING SERVICE TO NEW BUILDING. ANY/ALL COSTS INCURRED FROM UTILITY FOR INSTALLATION OF THE NEW ELECTRICAL SERVICE SHALL BE INCLUDED IN CONTRACTOR'S BID.
- 3. REFER TO LIGHTING PLANS FOR BUILDING MOUNTED LIGHTING CIRCUITING AND EMERGENCY EGRESS REQUIREMENTS.

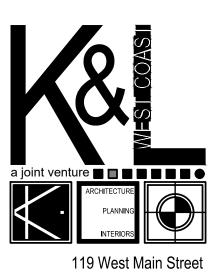

NORMAN, OK 73069 405.579.7883 FAX 405.292.0545

CIVIL CONSULTANT:

PHONE: FAX[.]

STRUCTURAL CONSULTANT: KFC ENGINEERING 525 CENTERAL PARK DR., SUITE 202 OKLAHOMA CITY, OK 73105 PHONE: 405.528.4596 FAX:

MECHANICAL CONSULTANT: ALLEN CONSULTING INC. 110 N. MERCEDES DR, SUITE 100 NORMAN, OK 73069 PHONE: 405.447.2282 FAX:

ELECTRICAL CONSULTANT: ALLEN CONSULTING INC. 100 N. MERCEDES DR, SUITE 100 NORMAN, OK 73069 PHONE: 405.447.2282 FAX:

ALPHA TAU OMEGA UNIVERSITY OF NEW HAMPSHIRE 18 GARRISON AVE. DURHAM, NH 03824

60% SET 07.23.19

MARK	DATE	DESCRIPTION							
REVISIONS									
-									
PRIMARY ISSUE									
MARK	DATE	DESCRIPTION							
	00.00.00	PERMIT ISSUE							
	00.00.00	BID ISSUE							
	00.00.00	CONST. ISSUE							


NOT FOR CONSTRUCTION

THESE DRAWINGS ARE PROVIDED FOR APPROVAL OR REVIEW PURPOSES ONLY AND DO NOT IN ANY WAY CONSTITUTE A CONSTRUCTION DOCUMENT SET; AS SUCH, THESE DRAWINGS MAY NOT BE INCORPORATED INTO ANY SET OF DRAWINGS USED FOR CONSTRUCTION.

JOB NO.:	K0418						
© 2019 KRITTENBRINK ARCHITECTURE LLC ALL RIGHTS RESERVED THESE DOCUMENTS NOT BE USED FOR ANY PURPOSES WITHOUT PRIOR WRITTEN PERMISSION FROM KRITTENBRINK ARCHITECTURE LLC							
DRAWN BY	CHECKED BY						
PWH							

 SHEET TITLE: ELECTRICAL SITE PLAN






UNIT



ELEC. SITE PLAN

EHRO

0.4 0.4 0.4 0.3 0.3 0.3 0.3 0.3 0.3 0.4 0.4 0.4 0.4 (0.4) (0.5) (0.6) 0.7 0.1 0.6 0.6 0.6 0.5 0.5 0.5 0.0 0.0 0.1 0.4 $1.0 \quad 0.8 \quad 0.6 \quad 0.5 \quad 0.5 \quad 0.6 \quad 0.7 \quad 1.0_{1}$ 0.9 0.0 0.0 0.3 0.5 0.0 1.2 1.3 1.1 0.8 0.6 0.5 0.6 0.7 0.9 0.0 1.2 1.5 1.6 1.5 0.7 0.9/ 0.0 1.4 1.7 1,9 1.8 1.5 0.0 0.0 0.0 /2.1 2.2 1.3 1.4 1.9 0.0 0.0 0.0 2.3 2.4 2.3 1.8 **2.1** 0.0 0.0 0.0 2.9 2.6 2,5 2.1 1.6 *2*.9 0.0 0.0 0.0 10.4 2.5 2.4 **_**3.0_ 0.0 0.0 0.0 2.5 2.3 3.1 0.0 0.0 0.0 2.2 2.1 20 0.0 0.0 0.0 0.5 1.8 1.8 1.7 1.5 1.2 0.0 0.0 ****0.1 1.4 1.5 1.4 1.3 0.0 0.0 0.0 0.3 1.1 0.0 0.0 0.5 **V**0.1 0.Q` 0.7 0.0 0.0 0.0 1 🍾 0.2 0.5 0.0 0.0 0.1 0.0 \ 0.0 0.0 0.0 0.1 0.1 0.0 0.0 0.0 0.1 0.0 0.0 0.0 0.0 0.0 0.0 0.0 0.1 0.0 0.0 0.0 0.0 0.0 0.0 0.0 0.0 0.0

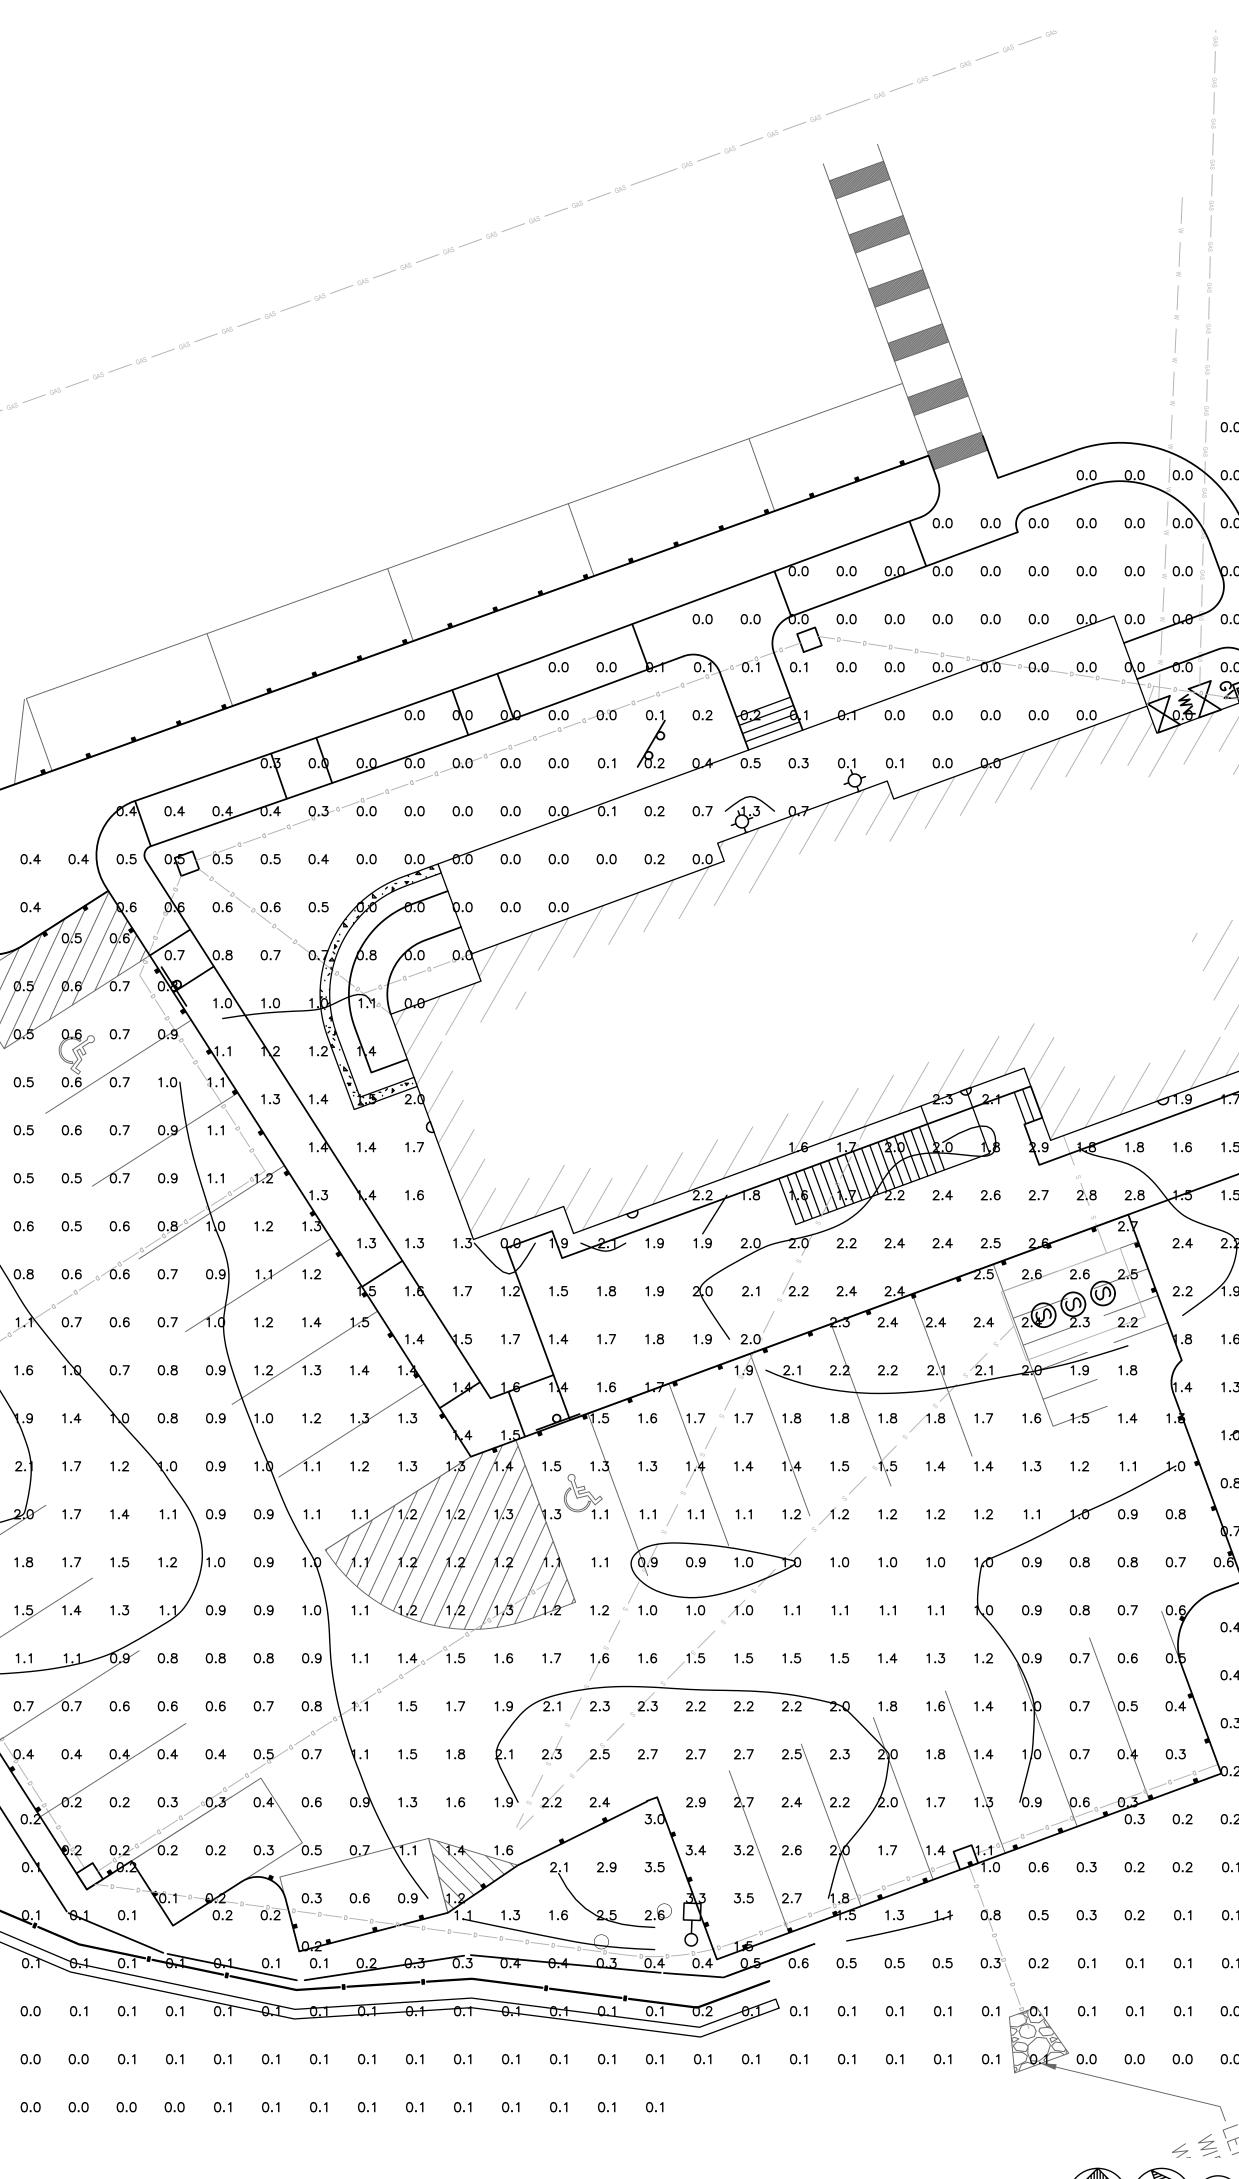

GENERAL NOTES:

- 1. CONNECT ALL EXTERIOR LIGHTING WITH #10 IN 1" PVC BURIED A MINIMUM OF 24" BELOW GRADE UNLESS NOTED OTHERWISE.
- 2. ELECTRICAL CONTRACTOR SHALL COORDINATE EXACT REQUIREMENTS WITH UTILITY TO PROVIDE ALL PARTS, TRENCHING, AND PAY ALL FEES NECESSARY TO BRING SERVICE TO NEW BUILDING. ANY/ALL COSTS INCURRED FROM UTILITY FOR INSTALLATION OF THE NEW ELECTRICAL SERVICE SHALL BE INCLUDED IN CONTRACTOR'S BID.


3. REFER TO LIGHTING PLANS FOR BUILDING MOUNTED LIGHTING CIRCUITING AND EMERGENCY EGRESS REQUIREMENTS.

		/																405.5
- GAS		/	0.0														F/	AX 405.2
) 0. 0	ی ۵ 0.0	0.0	0.0									_			_		ISULTANT	:
; 0.0	ة 0 0.0	0.0	0.0						OT-CAND	DMETRIC S	1.29				-			
- GAS	୍ଦ କ						MAX	IMUM FO	OT-CAND	ILES	3.5					PHONE:		
0.0		0.0	0.0						DT-CAND		0.1				_	FAX:		
.	0.0	0.0	0.0	0.0						FC RAT					_	STRUCTU	NGINE	ERING
										FC RATI						525 CEN OKLAHC	MA CIT	Y, OK 731
0.0		0.0	0.0	0.0							•				_	PHONE: 4 FAX:	00.028.4	1990
0.0		0.0	0.0	0.0					UTSIDE C		NG AREA		etric s	CHEDULE	_			
7.2	F 0.0) 0.0	0.0	0.0	0.0				OT-CAND		3.5				_	110 N. M	ERCED	ES DR, S
		,					MINI	MUM FO	DT-CAND	LES	0.0					NORMAN PHONE: 4		
/	0.0	0.0	0.0	0.0	0.0					FC RAT	_					FAX:		
	/	0.0	0.0	0.0	0.0					FC RAT		/ 0.00					I CON	SULTIN
												/ 0.00				100 N. M NORMAN	N, OK 73	069
		0.0	0.0	0.0	0.0											PHONE: 4 FAX:	00.447.2	2202
/		<u>d</u> .0	0.0	0.0	0.0	0.0										ALP	на т	
	0.0	0.0	0.0	0.0	0.0	0.2												
	B															NEV		
/	/ do	0.0	\0.0	0.4		0.3												RISO
	<u>)</u> .0	0.9	0,6	0.5		0.4	0.4									DUR		
				0.7	O_{\perp}		~ /											·
<u> </u>	1.3	1.0	0.8	0.7	4 (0.6	0.5	0.4											
1.5	5 1.3	-1.1	1.0	0.8	0.7	0.6	0.5											SET
1.5	5 1.3	1.2	1.1	0.9	0.7	0.6	0.5										07.2	23.19
_																		
2.	2 1.3	1.2	1.0	0.9	0.7	0.6	0.5	0.4										_
/1.9	9 1.7	1.5	0 .9	0.8	0.6	0.5	0.4	0.4										
1 (- 1 4	1.2		0.6	0.5	0.4	0.4	0.3										
1.6	5 1.4	1.2	1.1	0.0	0.5	0.4	0.4	0.5										
1.3	3 1.1	1.0	0.8	0.7	0.6	0.4	0.3	0.3	0.2									
1.6	0.9	0.8	0.7	0.6	0.5	0.5	0.4	0.2	0.2									
L.																MARK	DATE	
0.8	8 0.7	0.6	0.5	0.5	0.4	0.4	0.3	0.3	0.2								REVIS	SIONS
Q. 7	7 0.6	0.5	0.4	0.4	0.3	0.3	0.3	0.2	0.2							PF	RIMAR	Y ISSL
0.6	0.5	0.4	0.4	0.3	0.3	0.2	0.2	0.2	0.2	0.1						MARK	DATE	DESCF PERMI
	- 0.0	0.4	0.4	0.0	0.0	0.2	0.2	0.2	0.2	0.1							00.00.00	
0.4	4 0.4	0.3	0.3	0.2	0.2	0.2	0.2	0.1	0.1	0.1							00.00.00	
0.4	4 0.3	0.3	0.2	0.2	0.2	0.2	0.1	0.1	0.1	0.1							NOT	
																CC		FOR RUCTIO
) 0.3	3 0.2	0.2	0.2	0.2	0.1	0.1	0.1	0.1	0.1	0.1	0.1							
Jo.:	2 0.2	0.2	0.1	0.1	0.1	0.1	0.1	0.1	0.1	0.1	0.1					REVIEW PU CONSTITUT	IRPOSES ONLY E A CONSTRU	OVIDED FOR AF / AND DO NOT I CTION DOCUME /AY NOT BE INC
0.2	2 0.1	0.1	0.1	0.1	0.1	0.1	0.1	0.1	0.1	0.0	0.0							S USED FOR CC
0.2	2 0.1	0.1	0.1	0.1	0.1	0.1	0.1	0.1	0.1	0.0	0.0							
0.	1 0.1	0.1	0.1	0.1	0.1	0.1	0.1	0.0	0.0	0.0	0.0	0.0				JOB	NO.	: K04
0.	1 0.1	0.1	0.1	0.1	0.0	0.0	0.0	0.0	0.0	0.0	0.0	0.0				RESERVED TH PURPOSES WI	ese documen Thout Prior	WRITTEN PERM
				_								_				KRITTENBRINK	ARCHITECTU	RE LLC
0.	1 0.1	0.1	0.0	0.0	0.0	0.0	0.0	0.0	0.0	0.0	0.0	0.0				DRAV PV		CHECK
0.0	0.0	0.0	0.0	0.0	0.0	0.0	0.0	0.0	0.0	0.0	0.0	0.0				SHEET TI		
0.0	0.0	0.0	0.0	0.0	0.0	0.0	0.0	0.0	0.0	0.0	0.0	0.0	0.0			ELEC		CAL
5.0		2.0	2.0	2.0	2.0	0.0	2.0	2.0		2.0	2.0	2.0	2.0			PHO	ТОМ	ETRI



NORTH



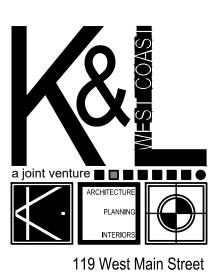

NORMAN, OK 73069 405.579.7883 5.292.0545

DR., SUITE 202 73105

ING INC. R, SUITE 100

TING INC. , SUITE 100

J OMEGA ΓΥ OF PSHIRE SON AVE. NH 03824

MARK	DATE	DESCRIPTION						
REVISIONS								
Pl	RIMARY	ISSUE						
MARK	DATE	DESCRIPTION						
	00.00.00	PERMIT ISSUE						
	00.00.00	BID ISSUE						
	00.00.00	CONST. ISSUE						

TION

OR APPROVAL OR NOT IN ANY WAY CUMENT SET; AS E INCORPORATED R CONSTRUCTION.

JOB NO.: K0418	
© 2019 KRITTENBRINK ARCHITECTURE LLC ALL RIGHTS	
RESERVED THESE DOCUMENTS NOT BE USED FOR ANY	
PURPOSES WITHOUT PRIOR WRITTEN PERMISSION FROM	V

ECKED BY

PHOTOMETRICS PLAN

SHEET NO .: E(

SCALE:1"=10'-0"